


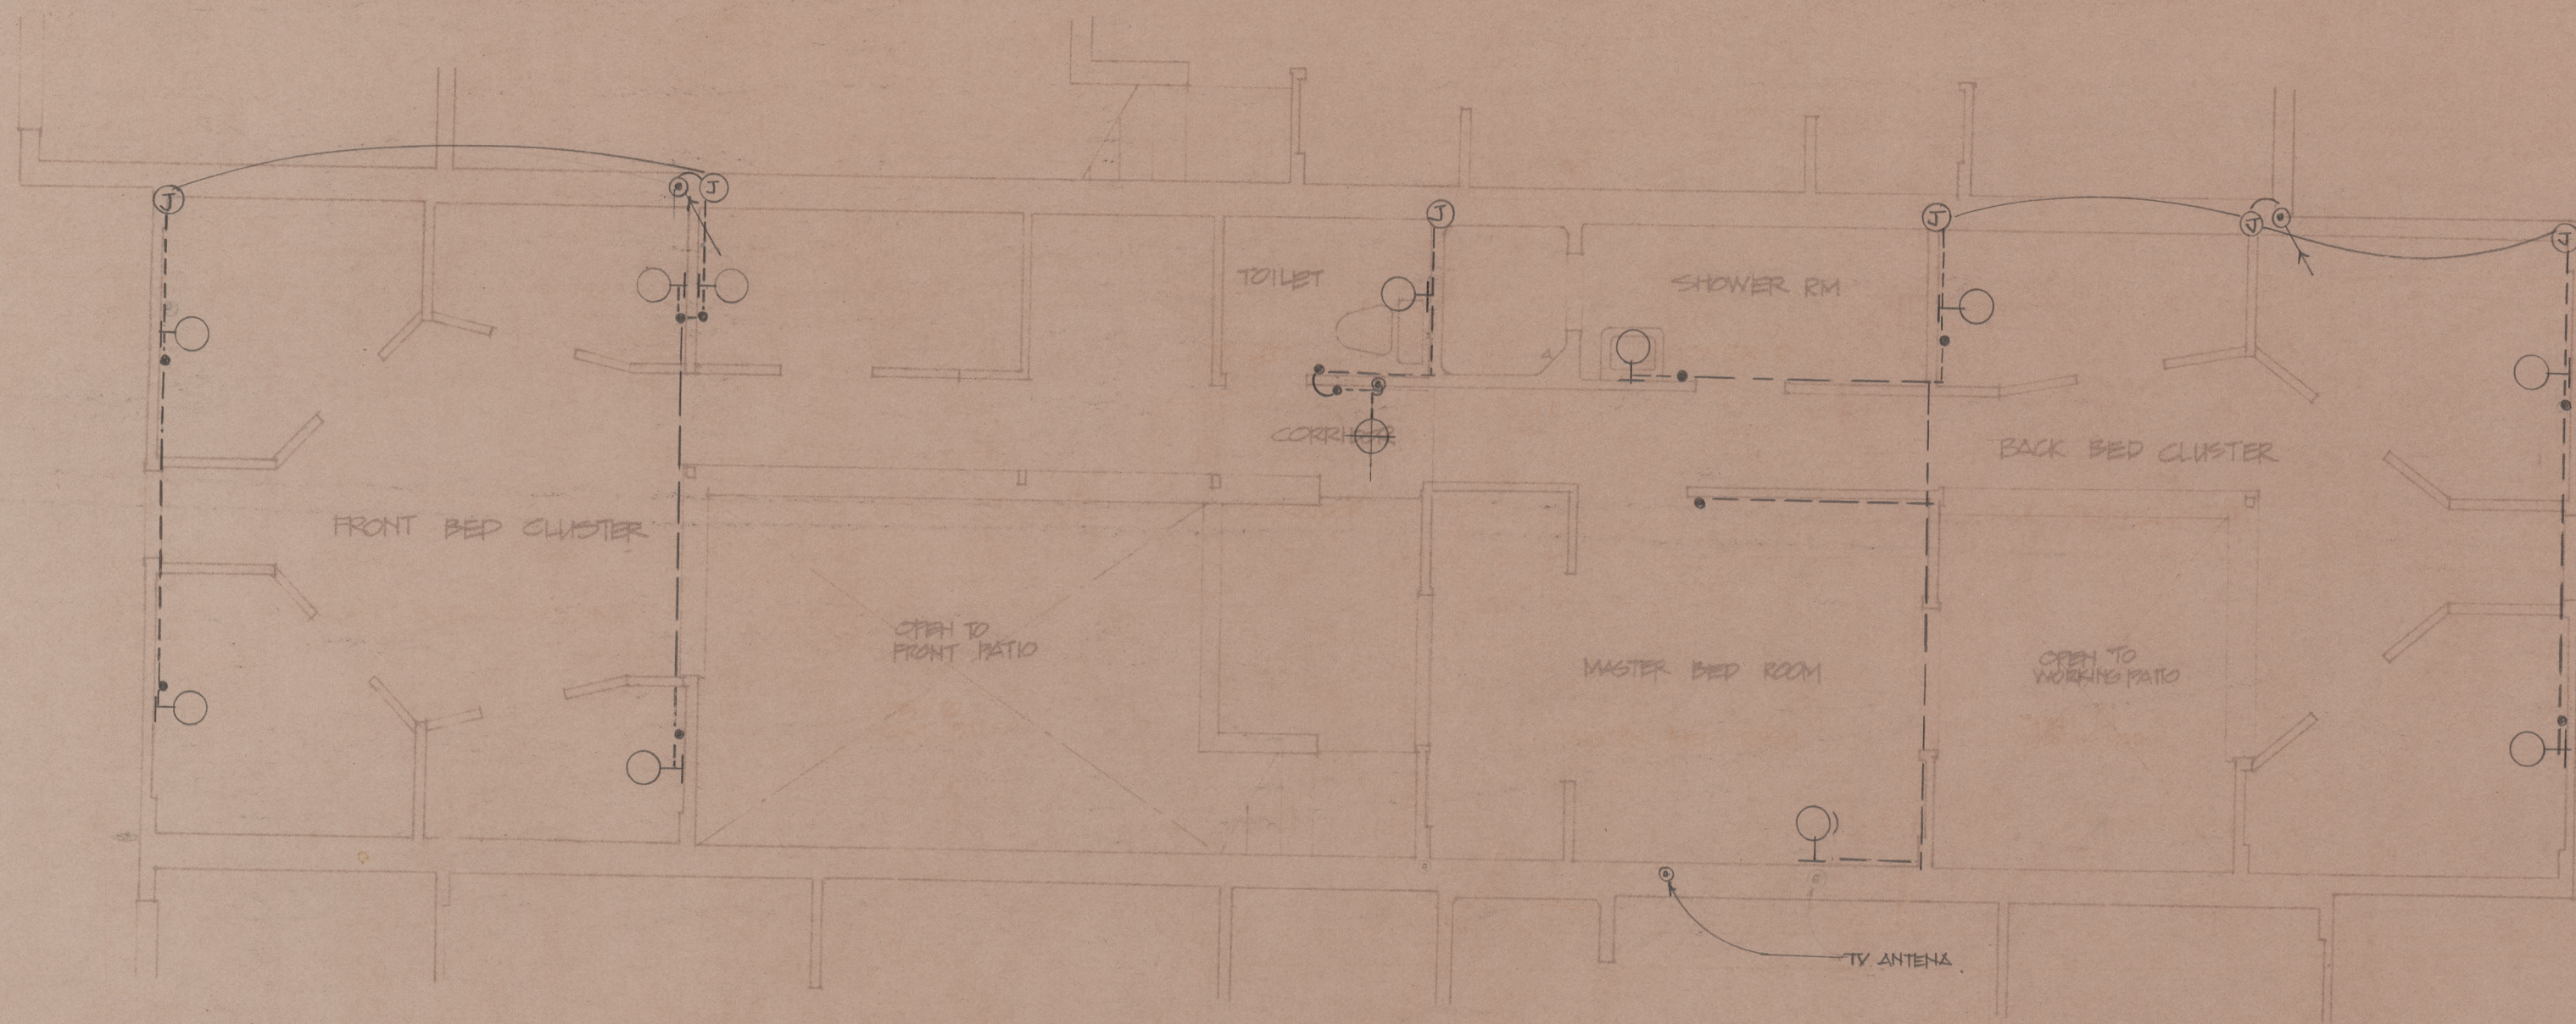


2ND FLOOR PLAN

CIRCUIT	PHASE	PIPE SIZE	AMP.	
1	S	5/8"	15A	
2	S	5/8"	15A	
3				SPARE

KEY

- BRACKET LIGHT
- CEILING LIGHT
- PLUG
- TV ANTENNA PLUG
- JUNCTION BOX
- SWITCH
- DISTRIBUTION PANEL
- METER
- BRANCH CIRCUIT CONCEALED IN CEILING OR WALL
- BRANCH CIRCUIT EXPOSED
- TELEPHONE

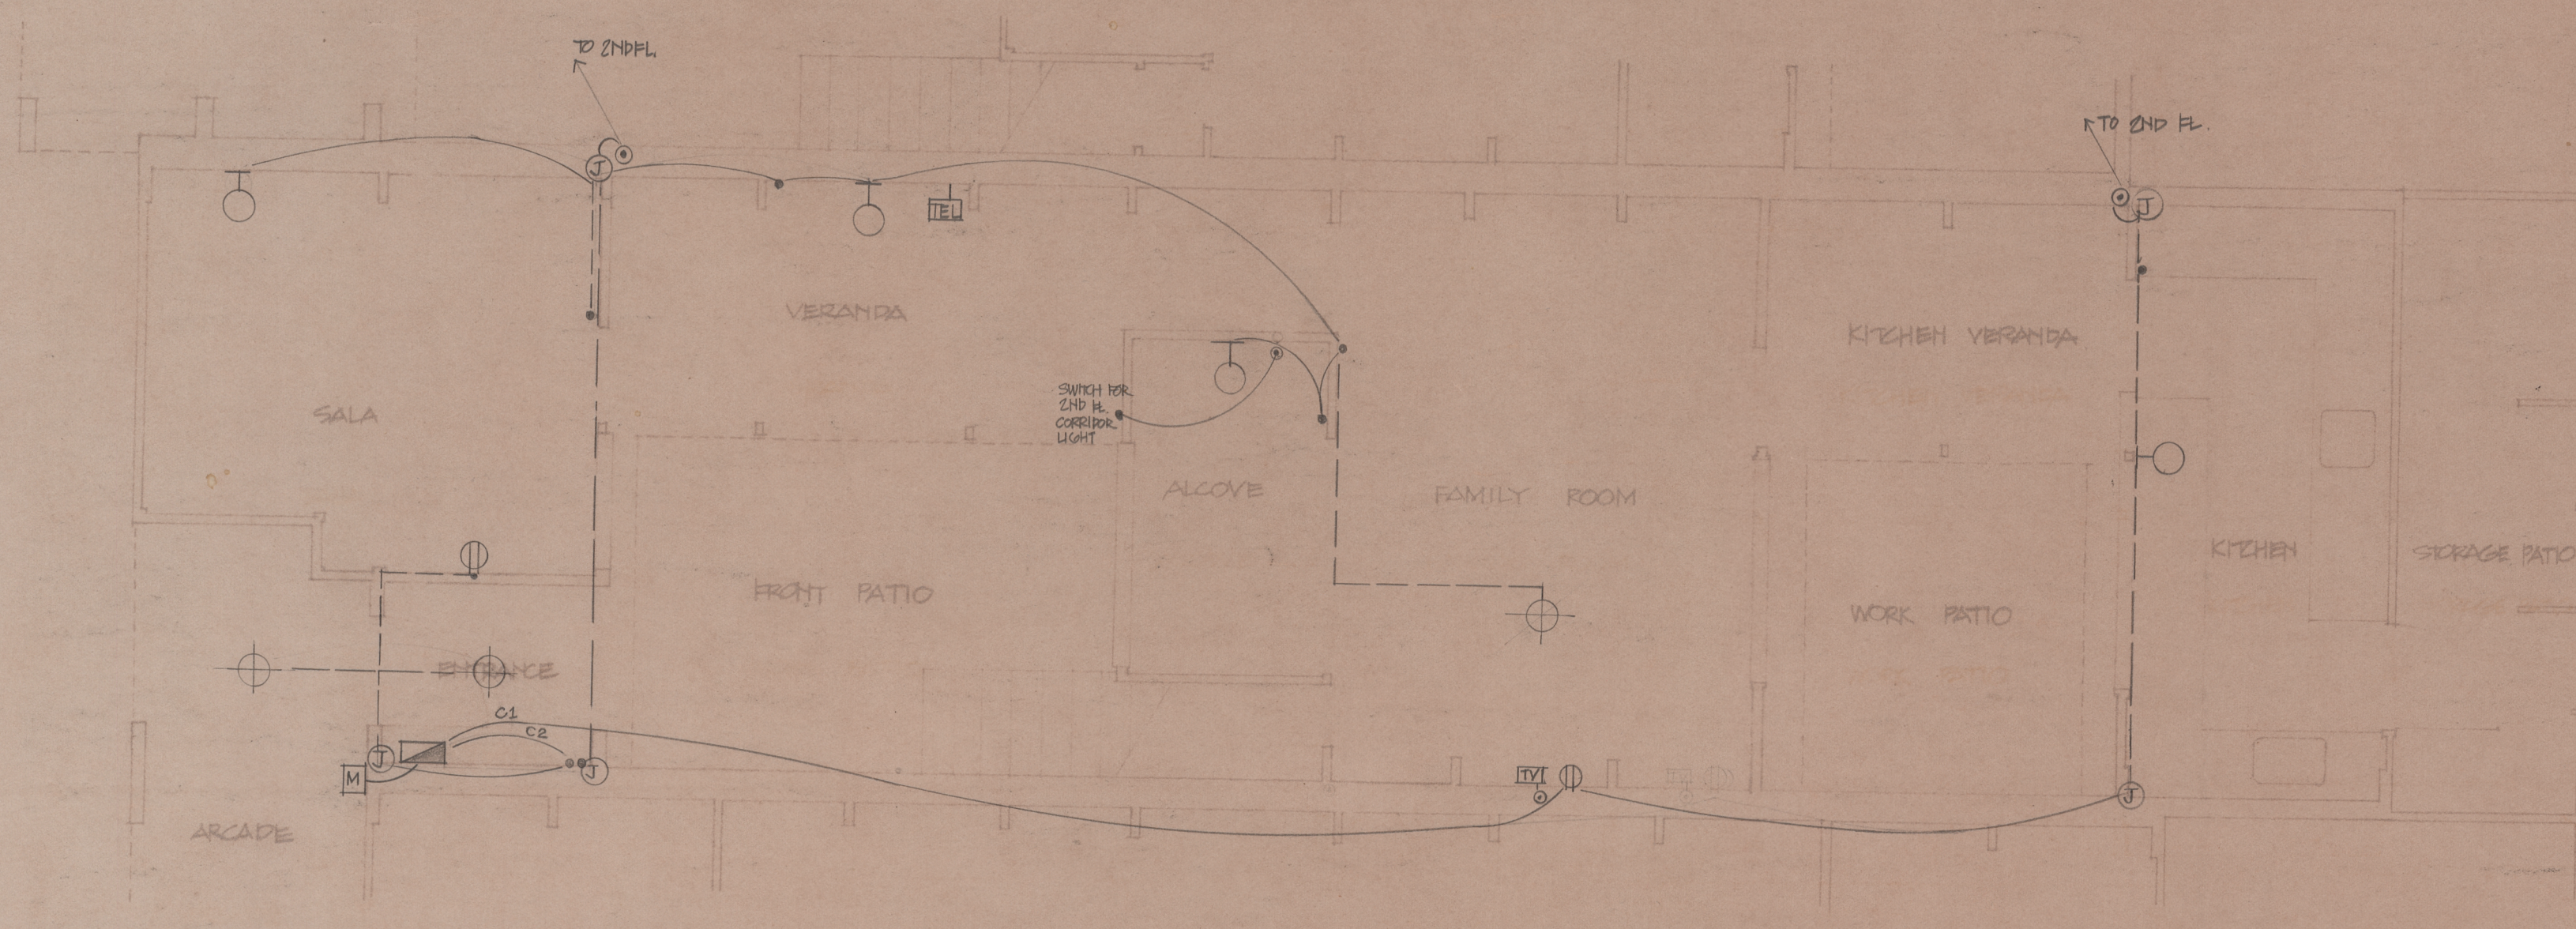

GROUND FLOOR PLAN

CENTER FOR
ENVIRONMENTAL
STRUCTURE
BERKELEY, CALIFORNIA

PROYECTO
EXPERIMENTAL
DE VIVIENDA
DE VIVIENDA

ELECTRIC PLAN

SCALE : 1" = 50'
DATE : SEPT. 30, 1971

E1